


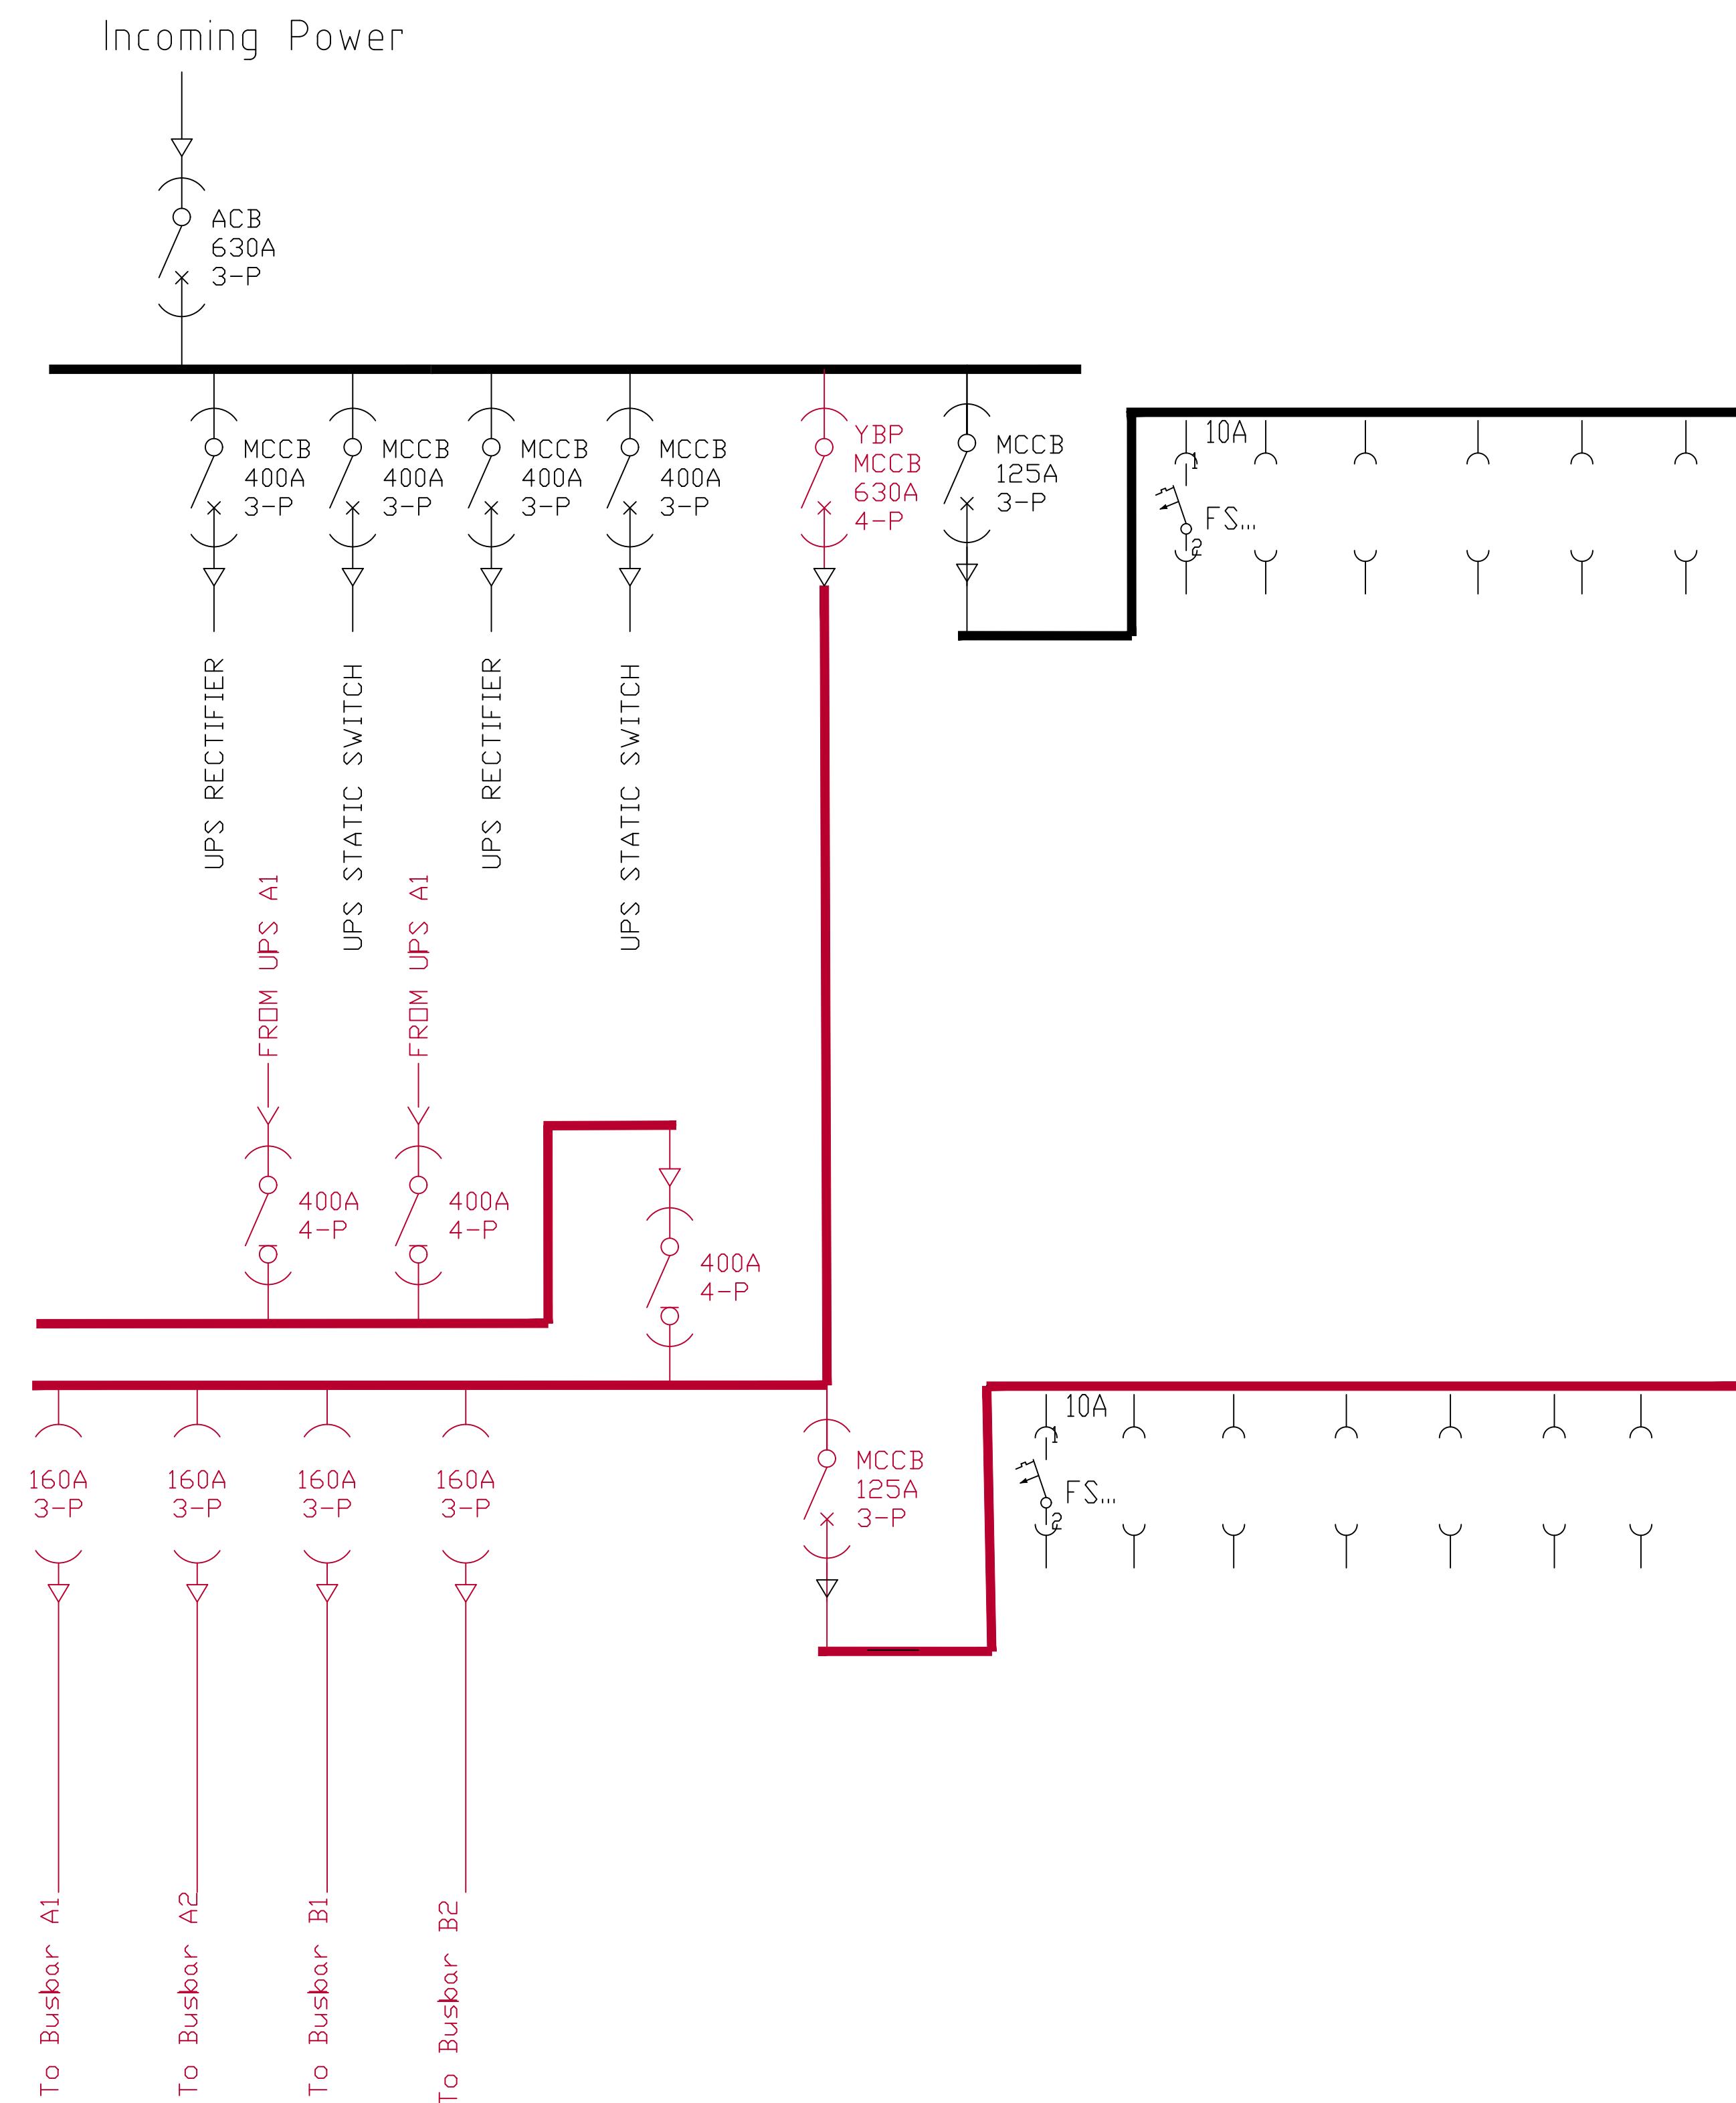

REV	NOTE	REVISION	SIGN	DATE
OPEN MDC 300kW				
SWEDISH MODULES				
PROJECT	RESPONSIBLE		MADE BY	
DATE	APPROVED BY			
2019-09-25	R.SÖDERHÅLL		M.GÄRDESTAM	
MCD				
SINGLE LINE DIAGRAM				
SCALE	DRAWING NUMBER			I REV
N/A	E-630-00-100			